


DATE	DESCRIPTION	DATE	DESCRIPTION
2-17-17	△		

Dispensary
 2403 Stagecoach Road
 Stockton, CA

Valerie Ehrke Design
 306 5th Street
 P.O. Box 1444
 Arbuckle, CA 95912
 (530) 681-1218

DRAWING INDEX	
A-1.0	COVER SHEET
A-2.1	SITE PLAN
A-2.2	EXISTING FLOOR PLAN
A-2.3	PROPOSED FLOOR PLAN
A-2.4	PROPOSED SECURITY PLAN
A-2.5	DETAILS
A-2.6	SITE ILLUMINATION PLAN

SHEET NO.
A2.1

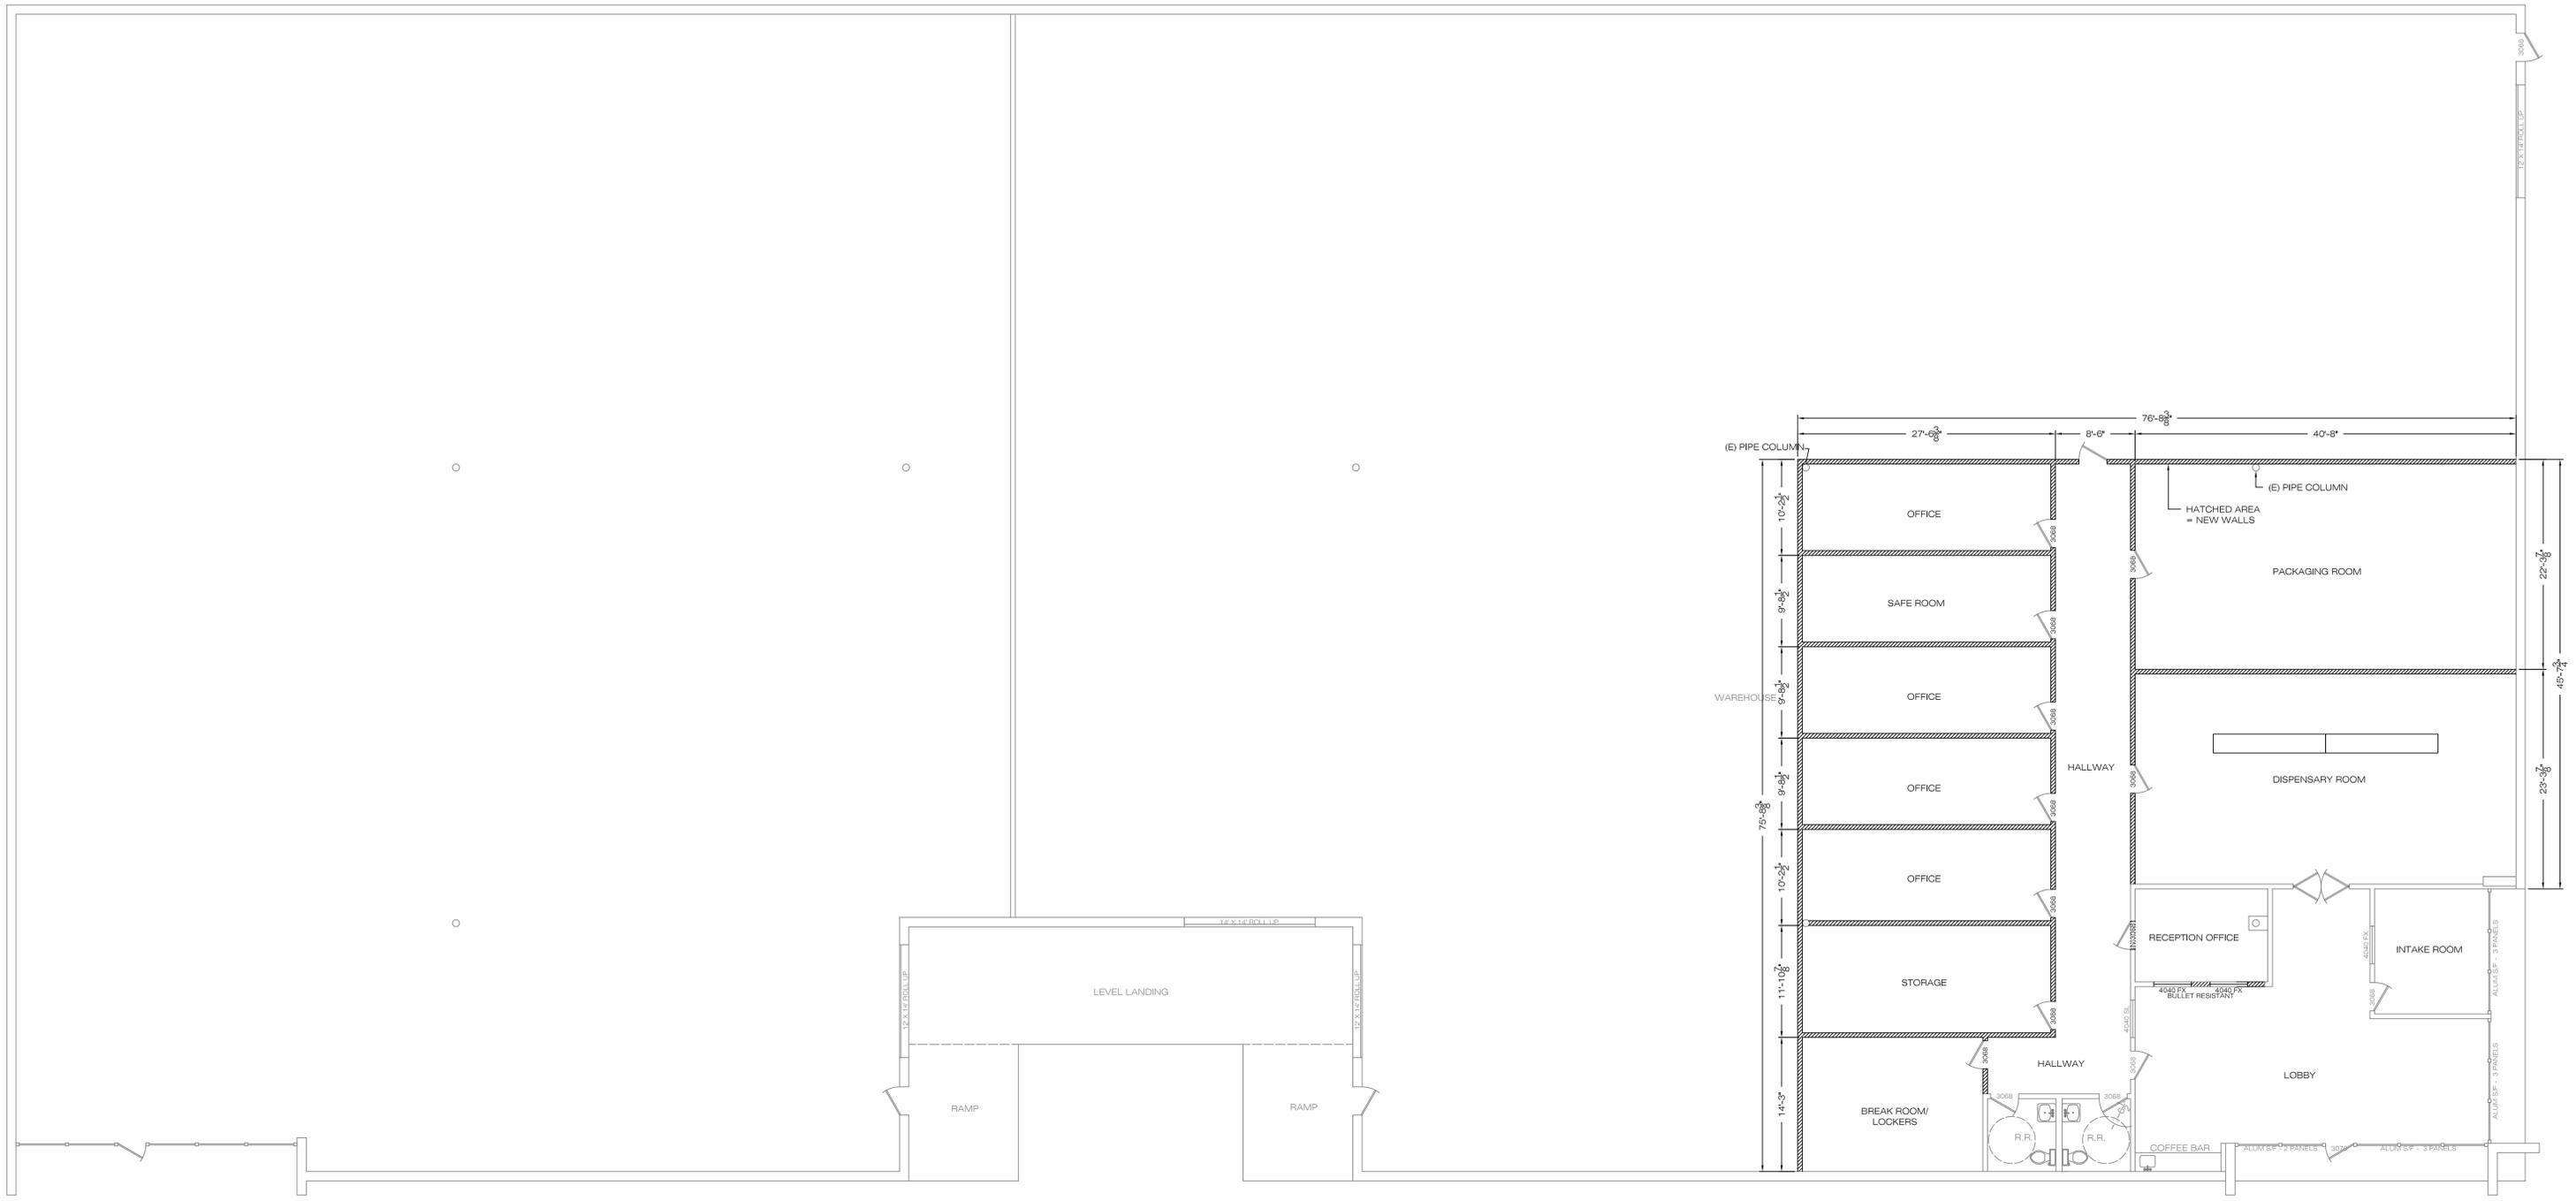

DRAWN BY: VEE	DATE: 2-17-17	PROJECT NO:	SCALE:
DATE	DESCRIPTION	DATE	DESCRIPTION

Dispensary
 2403 Stagecoach Road
 Stockton, CA

Valerie Ehrke Design
 306 5th Street
 P.O. Box 1444
 Arbuckle, CA 95912
 (530) 681-1218

DRAWING INDEX	
A-1.0	COVER SHEET
A-2.0	SITE PLAN
A-3.0	EXISTING FLOOR PLAN
A-4.0	PROPOSED FLOOR PLAN
A-5.0	PROPOSED SECURITY PLAN
A-6.0	DETAILS

SHEET NO. **A2.3**